



B SITE CONFIGURATIONS

Canopy fascia artwork for visualization purposes only

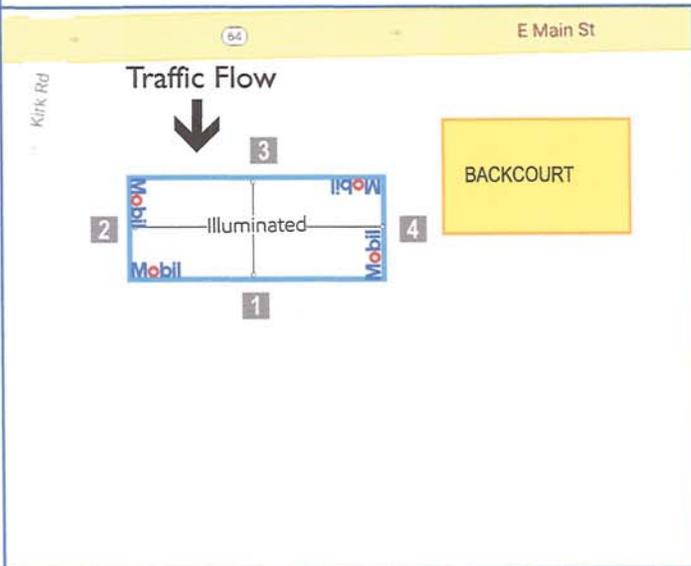


Overhead Map

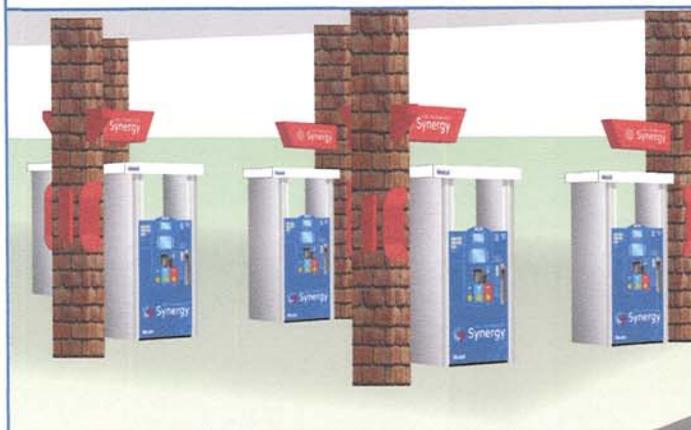

Canopy Perspective


1 | BACK ELEVATION

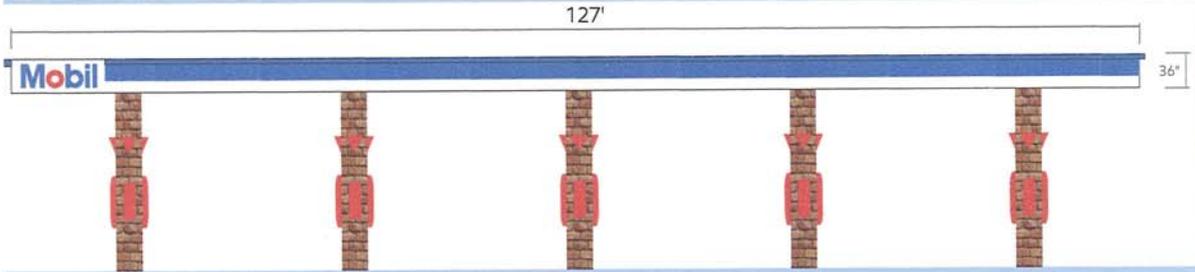


2 | RIGHT ELEVATION



3 | FRONT ELEVATION

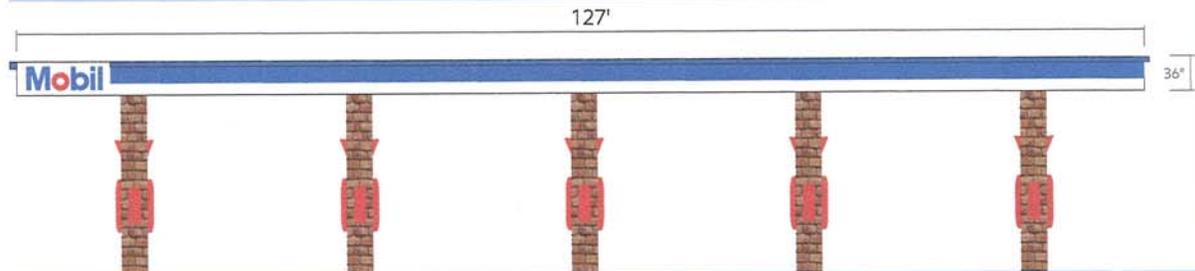


4 | LEFT ELEVATION

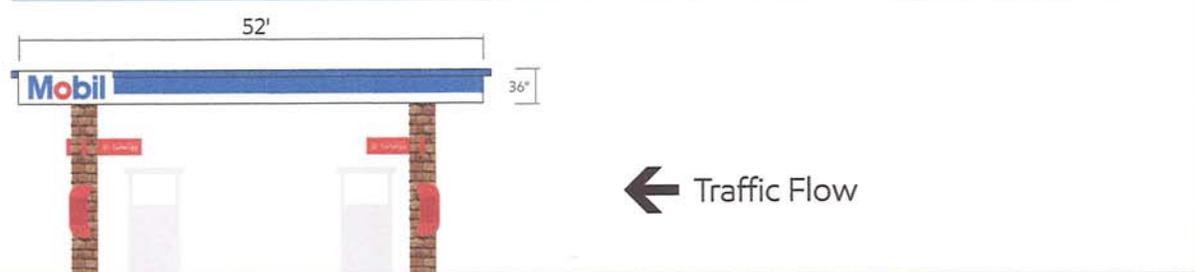

Project Name	PBL #	Customer	Created by
ExxonMobil	-	ExxonMobil	B.Dighero
Revision #	Date	Scale	Page #
R1	04_21_2020	NA	7 OF 16

Brand Book
 Site Image Materials Maintenance
 2 Northfield Plaza, Ste 250
 Northfield, IL 60093
 P: (847) 441-1818 F: (847) 592-9564

1

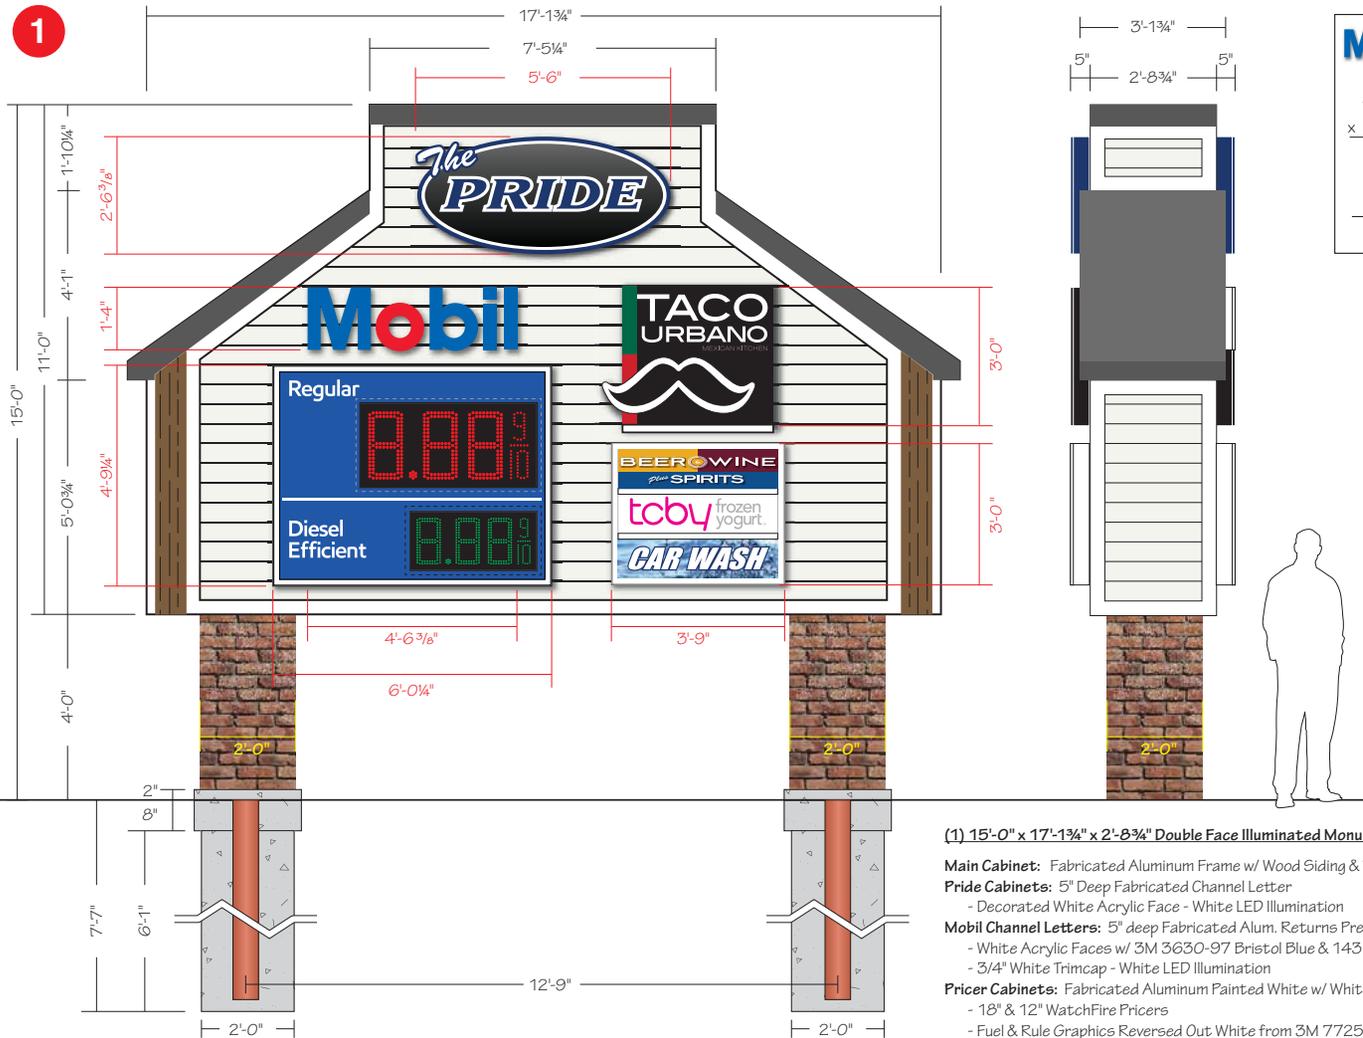

Mobil
16.000"
x 54.375"
870"
+144"
6 SF

8.88
57.25"
x 72.25"
4136"
4136"
+144"
29 SF

The PRIDE
30.375"
x 66.00"
2004.75"
2004.75"
+144.00"
14 SF

TACO URBANO
36.00"
x 45.00"
1620"
1620"
+144"
11 SF

BEER WINE SPIRITS
36.00"
x 45.00"
1620"
1620"
+144"
11 SF

6.0 SF
29.0 SF
14.0 SF
11.0 SF
+11.0 SF
71 SF
Signs

132.00"
x 205.75"
27159"
27159"
+144"
189 SF
Base

(1) 15'-0" x 17'-13/4" x 2'-8 3/4" Double Face Illuminated Monument Sign

Main Cabinet: Fabricated Aluminum Frame w/ Wood Siding & Trim to Match Building

Pride Cabinets: 5" Deep Fabricated Channel Letter

- Decorated White Acrylic Face - White LED Illumination

Mobil Channel Letters: 5" deep Fabricated Alum. Returns Prefinished White

- White Acrylic Faces w/ 3M 3630-97 Bristol Blue & 143 Poppy Red Trans. Vinyls

- 3/4" White Trimcap - White LED Illumination

Pricer Cabinets: Fabricated Aluminum Painted White w/ White Polycarb. Faces

- 18" & 12" WatchFire Pricers

- Fuel & Rule Graphics Reversed Out White from 3M 7725-17 Vivid Blue Vinyl

Taco Urbano Cabinets: 5" deep Fabricated Alum. Prefinished Black

- White Acrylic Face w/ 3M 7725-12 Black / 3630-76 Holly Green / 3630-33 Red Vinyls

- White LED Illumination

- 1" Black Trimcap

Sundry Cabinets: Fabricated Alum. Painted White - White Acrylic Tenant Panels

- Graphics = Digitally Printed on White Trans. Vinyl

- White LED Illumination

Power: (1) 20Amp @ 120 or 277Volts Electrical Circuits Run to Site by Others

Base Columns: CMU Block w/ Brick to Match Building

Mounting: (2) 6" (6 3/8") Sch. 40 Steel Pipes set into Concrete Piers

Parvin-Clauss
SIGN COMPANY

Design • Fabrication • Installation • Maintenance

165TubewayDrive • CarolStream • Illinois60188
Tel/630-510-2020 • Fax/630-510-2074
e-mail/signs@parvinclauss.com
www.parvinclauss.com

PROJECT:



SEC Kirk Road & Main Street (Rt. 64)
St. Charles, IL

CUSTOMER APPROVAL:

DATE

AUTHORIZED SIGNATURE

REPRESENTATIVE

House / RM / KZ

DRAWN BY

Bill Marlow

DATE

10.23.19

SCALE

3/8" = 1'

SHEET NO.

1 of 12

WORK ORDER

82989

FILE NAME

PRD82989

REVISIONS:

1 11.04.19 - center sundry cab.

2

3

4

5

6

7

8


This sign is intended to be installed in accordance with the requirements of Article 600 of the National Electrical Code and/or other applicable local codes. This includes proper grounding and bonding of the sign.



This sign is built to UL Standards for operation in North America.

This Document is owned by, and the information contained in it is proprietary to, Parvin-Clauss Sign Company. By receipt hereof the holder agrees not to use the information, disclose it to any third party, nor reproduce this document without the prior written consent of Parvin-Clauss Sign Company. Holder also agrees to immediately return this document upon request of Parvin-Clauss Sign Company."

© Copyright 2019 by Parvin-Clauss Sign Co.

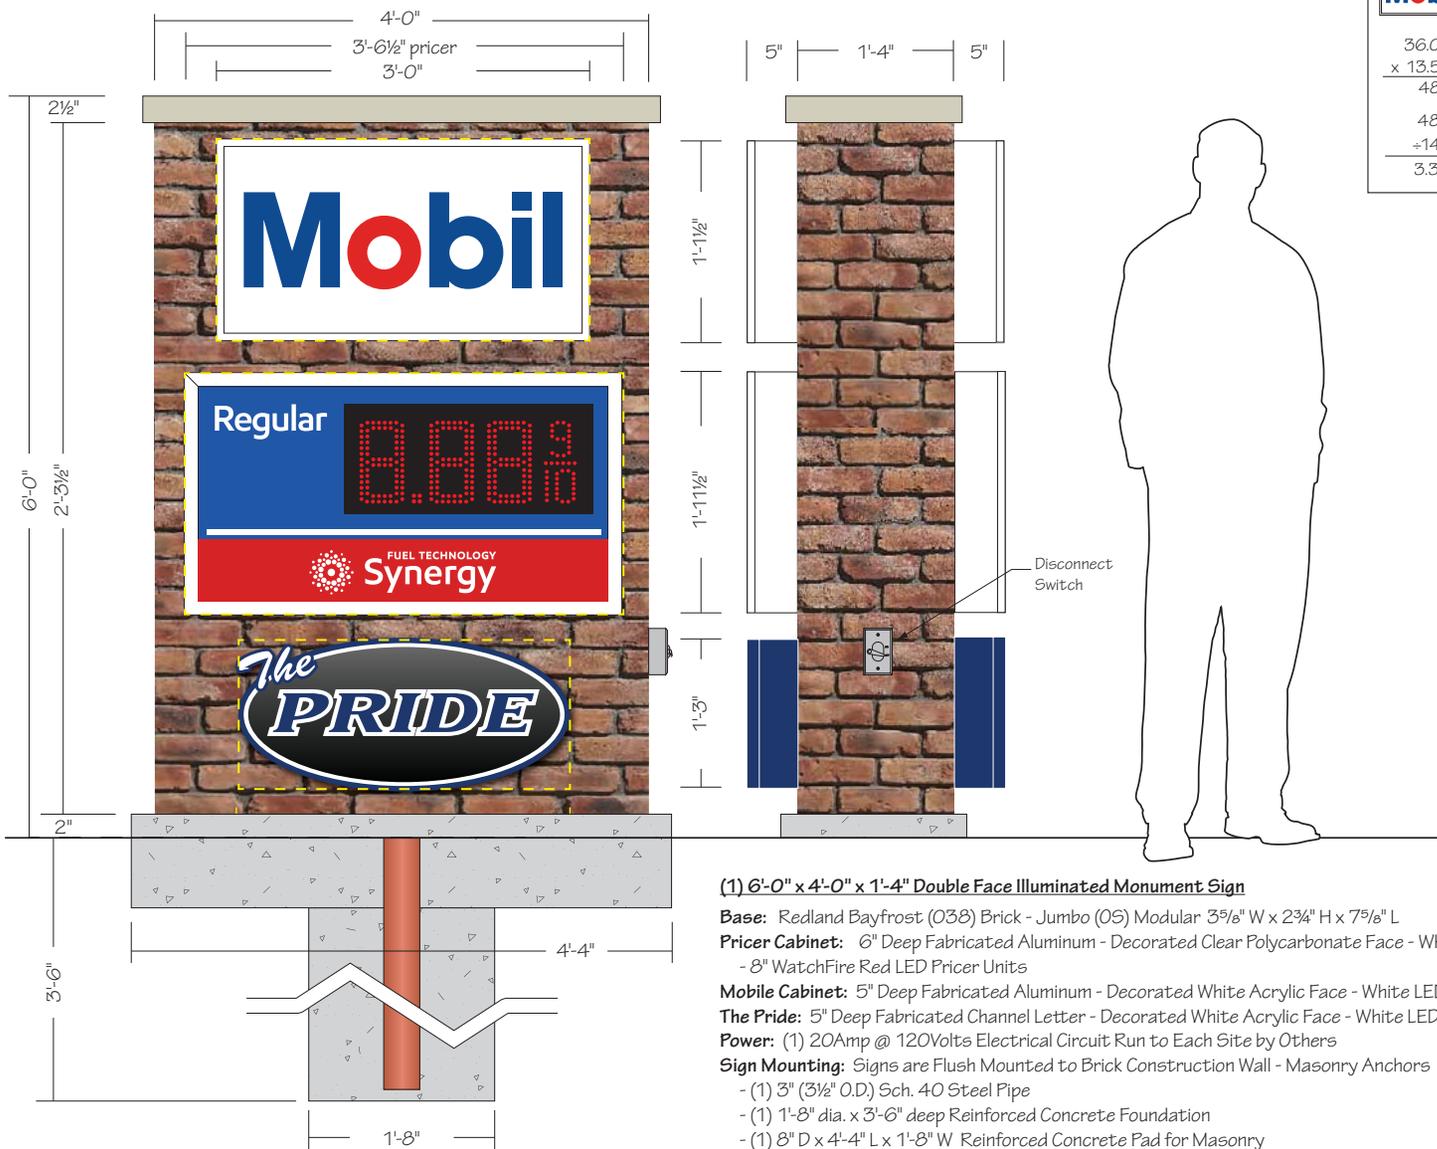

36.00"
x 13.50"
486"
486"
+144"
3.38 SF

42.50"
x 23.50"
998.75"
998.75"
+ 144"
7 SF

32.50"
x 15.00"
487.50"
487.50"
+144.00"
3.38 SF

3.38 SF
7.00 SF
+ 3.38 SF
13.76 SF
Signs

72.00"
x 48.00"
3456"
3456"
+144"
24 SF
Base

(1) 6'-0" x 4'-0" x 1'-4" Double Face Illuminated Monument Sign

Base: Redland Bayfrost (O38) Brick - Jumbo (OS) Modular 3⁵/₈" W x 2³/₄" H x 7⁵/₈" L

Pricer Cabinet: 6" Deep Fabricated Aluminum - Decorated Clear Polycarbonate Face - White LED Illumination
- 8" WatchFire Red LED Pricer Units

Mobile Cabinet: 5" Deep Fabricated Aluminum - Decorated White Acrylic Face - White LED Illumination

The Pride: 5" Deep Fabricated Channel Letter - Decorated White Acrylic Face - White LED Illumination

Power: (1) 20Amp @ 120Volts Electrical Circuit Run to Each Site by Others

Sign Mounting: Signs are Flush Mounted to Brick Construction Wall - Masonry Anchors

- (1) 3" (3 1/2" O.D.) Sch. 40 Steel Pipe
- (1) 1'-8" dia. x 3'-6" deep Reinforced Concrete Foundation
- (1) 8" D x 4'-4" L x 1'-8" W Reinforced Concrete Pad for Masonry

Parvin-Clauss
SIGN COMPANY

Design • Fabrication • Installation • Maintenance
165TubewayDrive • CarolStream • Illinois 60188
Tel/630-510-2020 • Fax/630-510-2074
e-mail/signs@parvinclauss.com
www.parvinclauss.com

PROJECT:



SEC Kirk Road & Main Street (Rt. 64)
St. Charles, IL

CUSTOMER APPROVAL:
DATE

AUTHORIZED SIGNATURE

REPRESENTATIVE
House / RM / KZ

DRAWN BY
Bill Marlow

DATE
10.23.19

SCALE
1" = 1'

SHEET NO.
2 of 12

WORK ORDER
82989

FILE NAME
PRD82989

REVISIONS:

- 1 11.04.19 - all cabs. on brick area
- 2
- 3
- 4
- 5
- 6
- 7
- 8


This sign is intended to be installed in accordance with the requirements of Article 600 of the National Electrical Code and/or other applicable local codes. This includes proper grounding and bonding of the sign.



This sign is built to UL Standards for operation in North America.

This Document is owned by, and the information contained in it is proprietary to, Parvin-Clauss Sign Company. By receipt hereof the holder agrees not to use the information, disclose it to any third party, nor reproduce this document without the prior written consent of Parvin-Clauss Sign Company. Holder also agrees to immediately return this document upon request of Parvin-Clauss Sign Company.

© Copyright 2019 by Parvin-Clauss Sign Co.

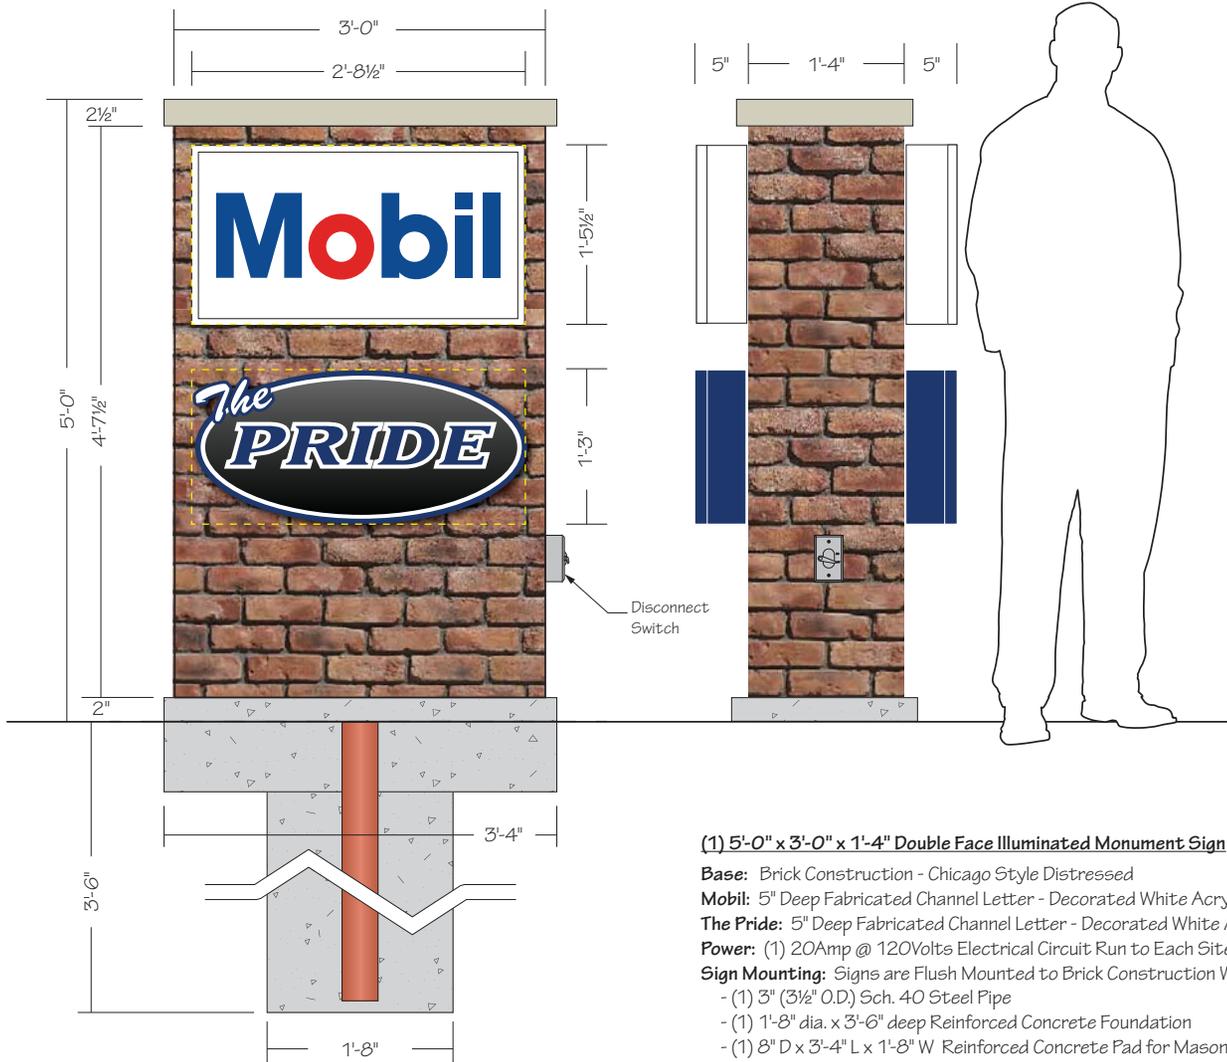

(1) 5'-0" x 3'-0" x 1'-4" Double Face Illuminated Monument Sign

- Base:** Brick Construction - Chicago Style Distressed
- Mobil:** 5" Deep Fabricated Channel Letter - Decorated White Acrylic Face - White LED Illumination
- The Pride:** 5" Deep Fabricated Channel Letter - Decorated White Acrylic Face - White LED Illumination
- Power:** (1) 20Amp @ 120Volts Electrical Circuit Run to Each Site by Others
- Sign Mounting:** Signs are Flush Mounted to Brick Construction Wall - Masonry Anchors
 - (1) 3" (3 1/2" O.D.) Sch. 40 Steel Pipe
 - (1) 1'-8" dia. x 3'-6" deep Reinforced Concrete Foundation
 - (1) 8" D x 3'-4" L x 1'-8" W Reinforced Concrete Pad for Masonry

$\begin{array}{r} 32.50'' \\ \times 17.50'' \\ \hline 568.75'' \\ +144'' \\ \hline 4\text{ SF} \end{array}$	 $\begin{array}{r} 32.50'' \\ \times 15.00'' \\ \hline 487.50'' \\ +144'' \\ \hline 3.38\text{ SF} \end{array}$
---	--

$\begin{array}{r} 4.00\text{ SF} \\ + 3.38\text{ SF} \\ \hline 7.38\text{ SF} \end{array}$ <p>Signs</p>	$\begin{array}{r} 60'' \\ \times 36'' \\ \hline 2160'' \\ + 144'' \\ \hline 15\text{ SF} \end{array}$ <p>Base</p>
---	---

Parvin-Clauss
SIGN COMPANY

Design • Fabrication • Installation • Maintenance
165TubewayDrive • CarolStream • Illinois60188
Tel/630-510-2020 • Fax/630-510-2074
e-mail/signs@parvinclauss.com
www.parcincnauss.com

PROJECT:



SEC Kirk Road & Main Street (Rt. 64)
St. Charles, IL

CUSTOMER APPROVAL:

DATE
AUTHORIZED SIGNATURE

REPRESENTATIVE
House / RM / KZ

DRAWN BY
Bill Marlow

DATE
10.23.19

SCALE
1" = 1'

SHEET NO.
3 of 12

WORK ORDER
82989


FILE NAME
PRD82989

REVISIONS:

1	11.04.19
2	
3	
4	
5	
6	
7	
8	


This sign is intended to be installed in accordance with the requirements of Article 600 of the National Electrical Code and/or other applicable local codes. This includes proper grounding and bonding of the sign.

4

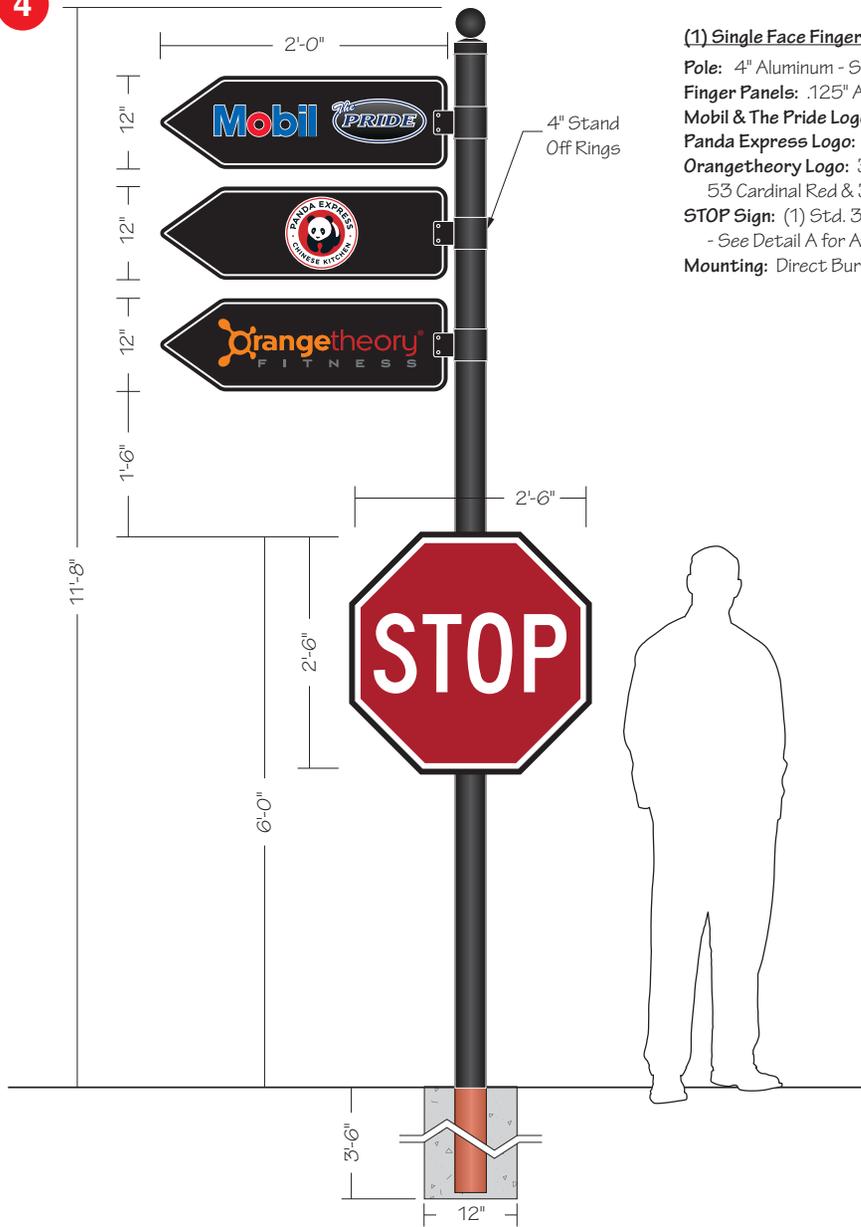

(1) Single Face Fingerpost Directional Sign

Pole: 4" Aluminum - Smooth - Painted Black - Ball Cap
Finger Panels: .125" Aluminum Painted Black w/ Reflective White Vinyl In-line Border
Mobil & The Pride Logos: Digitally Printed on White Vinyl Applied
Panda Express Logo: Digitally Printed on White Vinyl Applied
Orangetheory Logo: 3M 7725-14 Bright Orange, 53 Cardinal Red & 31 Medium Gray Vinyls Applied
STOP Sign: (1) Std. 30" x 30" Applied to .125" thick Black Aluminum Backer Panel
 - See Detail A for Attachment Hardware
Mounting: Direct Burial in 1'-0" dia. x 3'-6" deep Concrete Foundation

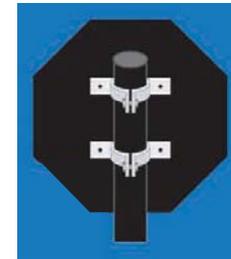

DETAIL A - Post Brackets



Parvin-Clauss
SIGN COMPANY

Design • Fabrication • Installation • Maintenance
 1165 Tubeway Drive • Carol Stream • Illinois 60188
 Tel/630-510-2020 • Fax/630-510-2074
 e-mail/signs@parvinclauss.com
 www.parvinclauss.com

PROJECT:



SEC Kirk Road & Main Street (Rt. 64)
 St. Charles, IL

CUSTOMER APPROVAL:
DATE

AUTHORIZED SIGNATURE

REPRESENTATIVE

House / RM / KZ

DRAWN BY

Bill Marlow

DATE

10.23.19

SCALE

3/4" = 1'

SHEET NO.

4 of 12

WORK ORDER

82989

FILE NAME

PRD82989

REVISIONS:

1	11.04.19
2	
3	
4	
5	
6	
7	
8	

This sign is intended to be installed in accordance with the requirements of Article 600 of the National Electrical Code and/or other applicable local codes. This includes proper grounding and bonding of the sign.



This sign is built to UL Standards for operation in North America.

"This Document is owned by, and the information contained in it is proprietary to, Parvin-Clauss Sign Company. By receipt hereof the holder agrees not to use the information, disclose it to any third party, nor reproduce this document without the prior written consent of Parvin-Clauss Sign Company. Holder also agrees to immediately return this document upon request of Parvin-Clauss Sign Company."


© Copyright 2019 by Parvin-Clauss Sign Co.

5



(1) 5'-4 5/8" x 11'-8 1/2" x 2" Deep SF Wall Sign w/ Illuminated Channel Letters

- Panel:** 2" Deep Fabricated Aluminum Painted PMS 288 Blue - Smooth Satin Finish
- Faces:** .125" Aluminum Painted PMS 288 Blue
- Inline Strip:** 3M 7725-10 White Vinyl
- Black/Grey Gradient:** Digitally Printed on Orajet 3751 RA White Vinyl Applied to Face
- Letters & White In-line:** Fabricated 3" Deep Channel Letters
- "The" Returns:** .040" Aluminum Painted PMS 288 Blue- 1" White Trimcap
- "PRIDE" & In-line Returns:** .040" Pre-finished White Aluminum - 1" White Trimcap
- Faces:** 732B White Acrylic w/ Avery UC 900-684T PMS 288 Blue Translucent Vinyl Applied to Faces
- Illumination:** White LEDs with Remote 60Watt Power Supplies
- Power:** Use Existing at Site
- Mounting:** Flush to Building with Anchors Appropriate for Wall Construction

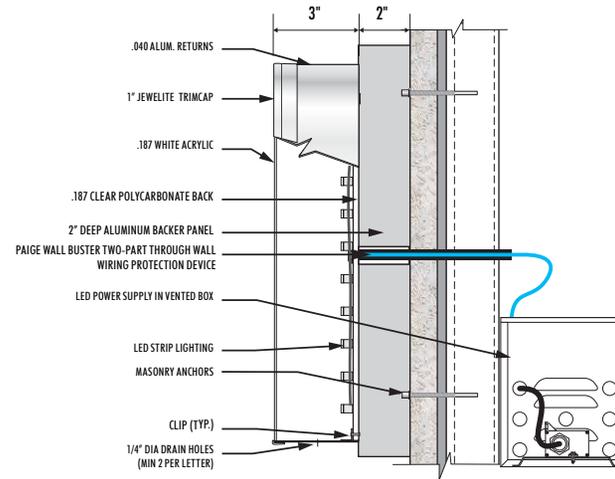

3" DEEP U/L APPROVED LED-ILLUMINATED CHANNEL LETTER - WIREWAY MOUNT



01 - SOUTH ELEVATION

Scale: 1/8" = 1'-0"

Parvin-Clauss
SIGN COMPANY

Design • Fabrication • Installation • Maintenance
165TubewayDrive • CarolStream • Illinois 60188
Tel/630-510-2020 • Fax/630-510-2074
e-mail/signs@parvinclauss.com
www.parvinclauss.com

PROJECT:



SEC Kirk Road & Main Street (Rt. 64)
St. Charles, IL

CUSTOMER APPROVAL:
DATE

AUTHORIZED SIGNATURE

REPRESENTATIVE

House / RM / KZ

DRAWN BY

Bill Marlow

DATE

10.23.19

SCALE

1/2" = 1'

SHEET NO.

5 of 12

WORK ORDER

82989

FILE NAME

PRD82989

REVISIONS:

1	11.04.19
2	
3	
4	
5	
6	
7	
8	

This sign is intended to be installed in accordance with the requirements of Article 600 of the National Electrical Code and/or other applicable local codes. This includes proper grounding and bonding of the sign.



This sign is built to UL Standards for operation in North America.

"This Document is owned by, and the information contained in it is proprietary to, Parvin-Clauss Sign Company. By receipt hereof the holder agrees not to use the information, disclose it to any third party, nor reproduce this document without the prior written consent of Parvin-Clauss Sign Company. Holder also agrees to immediately return this document upon request of Parvin-Clauss Sign Company."

© Copyright 2019 by Parvin-Clauss Sign Co.

6



(1) 5'-4 5/8" x 11'-8 1/2" x 2" Deep SF Wall Sign w/ Illuminated Channel Letters

Panel: 2" Deep Fabricated Aluminum Painted PMS 288 Blue - Smooth Satin Finish

Faces: .125" Aluminum Painted PMS 288 Blue

Inline Strip: 3M 7725-10 White Vinyl

Black/Grey Gradient: Digitally Printed on Orajet 3751 RA White Vinyl Applied to Face

Letters & White In-line: Fabricated 3" Deep Channel Letters

"The" Returns: .040" Aluminum Painted PMS 288 Blue- 1" White Trimcap


"PRIDE" & In-line Returns: .040" Pre-finished White Aluminum - 1" White Trimcap

Faces: 7328 White Acrylic w/ Avery UC 900-684T PMS 288 Blue Translucent Vinyl Applied to Faces

Illumination: White LEDs with Remote 60Watt Power Supplies

Power: Use Existing at Site

Mounting: Flush to Building with Anchors Appropriate for Wall Construction

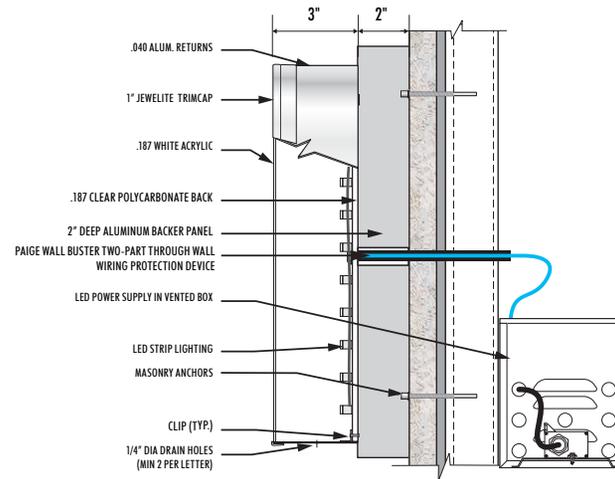

3" DEEP U/L APPROVED LED-ILLUMINATED CHANNEL LETTER - WIREWAY MOUNT



04 - NORTH ELEVATION

Scale: 1/8" = 1'-0"

Parvin-Clauss
SIGN COMPANY

Design • Fabrication • Installation • Maintenance
165TubewayDrive • CarolStream • Illinois60188
Tel/630-510-2020 • Fax/630-510-2074
e-mail/signs@parvinclauss.com
www.parvinclauss.com

PROJECT:



SEC Kirk Road & Main Street (Rt. 64)
St. Charles, IL

CUSTOMER APPROVAL:
DATE

AUTHORIZED SIGNATURE

REPRESENTATIVE

House / RM / KZ

DRAWN BY

Bill Marlow

DATE

10.23.19

SCALE

1/2" = 1'

SHEET NO.

6 of 12

WORK ORDER

82989

FILE NAME

PRD82989

REVISIONS:

1	11.04.19
2	
3	
4	
5	
6	
7	
8	


This sign is intended to be installed in accordance with the requirements of Article 600 of the National Electrical Code and/or other applicable local codes. This includes proper grounding and bonding of the sign.



This sign is built to UL Standards for operation in North America.

"This Document is owned by, and the information contained in it is proprietary to, Parvin-Clauss Sign Company. By receipt hereof the holder agrees not to use the information, disclose it to any third party, nor reproduce this document without the prior written consent of Parvin-Clauss Sign Company. Holder also agrees to immediately return this document upon request of Parvin-Clauss Sign Company."

© Copyright 2019 by Parvin-Clauss Sign Co.

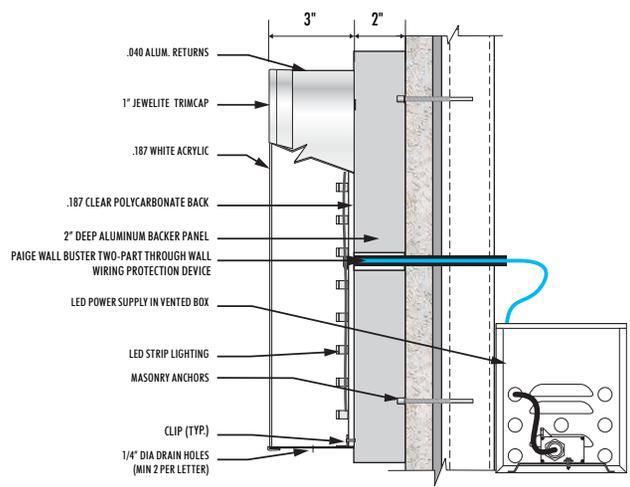

3\"/>

- (1) 3'-5 3/8" x 7'-6" x 2" Deep SF Wall Sign w/ Illuminated Channel Letters
- Panel:** 2" Deep Fabricated Aluminum Painted PMS 288 Blue - Smooth Satin Finish
- Faces:** .125" Aluminum Painted PMS 288 Blue
- Inline Strip:** 3M 7725-10 White Vinyl
- Black/Grey Gradient:** Digitally Printed on Orajet 3751 RA White Vinyl Applied to Face
- Letters & White In-line:** Fabricated 3" Deep Channel Letters
- "The" Returns:** .040" Aluminum Painted PMS 288 Blue- 1" White Trimcap
- "PRIDE" & In-line Returns:** .040" Pre-finished White Aluminum - 1" White Trimcap
- Faces:** 732B White Acrylic w/ Avery UC 900-684T PMS 288 Blue Translucent Vinyl Applied to Faces
- Illumination:** White LEDs with Remote 60Watt Power Supplies
- Power:** Use Existing at Site
- Mounting:** Flush to Building with Anchors Appropriate for Wall Construction



04 - SOUTH ELEVATION
3/16" = 1'-0"

PROJECT:



SEC Kirk Road & Main Street (Rt. 64)
St. Charles, IL

CUSTOMER APPROVAL:
DATE

AUTHORIZED SIGNATURE

REPRESENTATIVE

House / RM / KZ

DRAWN BY

Bill Marlow

DATE

10.23.19

SCALE

3/4" = 1'

SHEET NO.

7 of 12

WORK ORDER

82989

FILE NAME

PRD82989

REVISIONS:


1	11.04.19
2	
3	
4	
5	
6	
7	
8	

This sign is intended to be installed in accordance with the requirements of Article 600 of the National Electrical Code and/or other applicable local codes. This includes proper grounding and bonding of the sign.

This sign is built to UL Standards for operation in North America.


"This Document is owned by, and the information contained in it is proprietary to, Parvin-Clauss Sign Company. By receipt hereof the holder agrees not to use the information, disclose it to any third party, nor reproduce this document without the prior written consent of Parvin-Clauss Sign Company. Holder also agrees to immediately return this document upon request of Parvin-Clauss Sign Company."

© Copyright 2019 by Parvin-Clauss Sign Co.

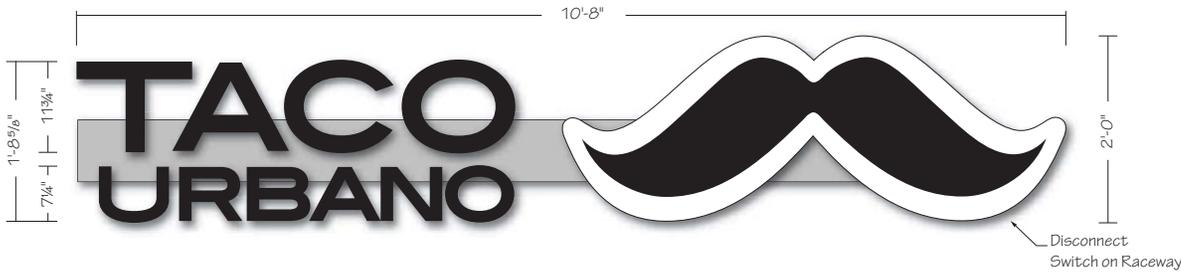

(1 set) 5" Deep Illuminated Channel Letters & Logo on Raceway

Letter & Logo Returns: .040" Fabricated Aluminum Prefinished Black
Letter Faces: White Acrylic w/ 3M 3635-222 Black Perforated Vinyl Applied - 3/4" Black Trimcap
Logo Face: White Acrylic w/ 3M 7725-12 Black Vinyl Applied - 3/4" Black Trimcap
Raceway: Std. 8" Narrow - Extruded Aluminum Painted to Match Wall Color
Illumination: White LEDs with 60Watt Power Supplies in Raceway
Power: (1) 20Amp @ 120Volt Electrical Circuit Run to Site by Others
Mounting: Flush to Building with Anchors Appropriate for Wall Construction

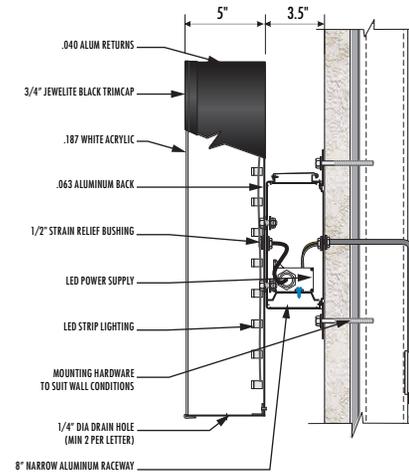

01 - SOUTH ELEVATION

Scale: 1/8" = 1'-0"

Design • Fabrication • Installation • Maintenance
 165 Tubeway Drive • Carol Stream • Illinois 60188
 Tel/630-510-2020 • Fax/630-510-2074
 e-mail/signs@parvinclauss.com
 www.parvinclauss.com

PROJECT:



SEC Kirk Road & Main Street (Rt. 64)
St. Charles, IL

CUSTOMER APPROVAL:
DATE

AUTHORIZED SIGNATURE

REPRESENTATIVE

House / RM / KZ

DRAWN BY

Bill Marlow

DATE

10.23.19

SCALE

3/4" = 1'

SHEET NO.

8 of 12

WORK ORDER

82989

FILE NAME

PRD82989

REVISIONS:


1	11.04.19
2	
3	
4	
5	
6	
7	
8	

This sign is intended to be installed in accordance with the requirements of Article 600 of the National Electrical Code and/or other applicable local codes. This includes proper grounding and bonding of the sign.

This sign is built to UL Standards for operation in North America.


"This Document is owned by, and the information contained in it is proprietary to, Parvin-Clauss Sign Company. By receipt hereof the holder agrees not to use the information, disclose it to any third party, nor reproduce this document without the prior written consent of Parvin-Clauss Sign Company. Holder also agrees to immediately return this document upon request of Parvin-Clauss Sign Company."

© Copyright 2019 by Parvin-Clauss Sign Co.

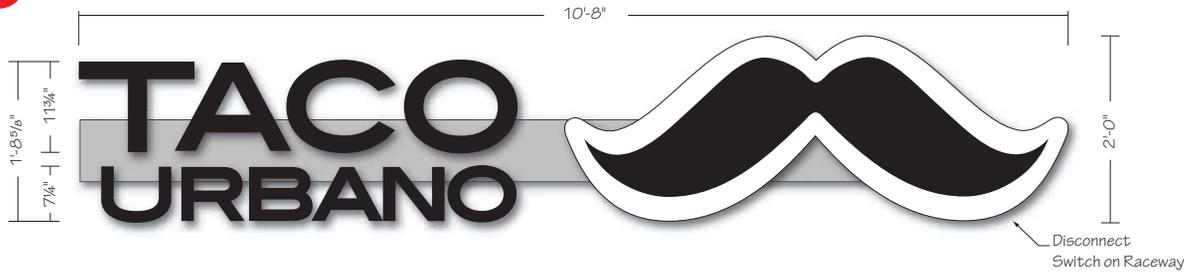

(1 set) 5" Deep Illuminated Channel Letters & Logo on Raceway

Letter & Logo Returns: .040" Fabricated Aluminum Prefinished Black
Letter Faces: White Acrylic w/ 3M 3635-222 Black Perforated Vinyl Applied - 3/4" Black Trimcap
Logo Face: White Acrylic w/ 3M 7725-12 Black Vinyl Applied - 3/4" Black Trimcap
Raceway: Std. 8" Narrow - Extruded Aluminum Painted to Match Wall Color
Illumination: White LEDs with 60Watt Power Supplies in Raceway
Power: (1) 20Amp @ 120Volt Electrical Circuit Run to Site by Others
Mounting: Flush to Building with Anchors Appropriate for Wall Construction

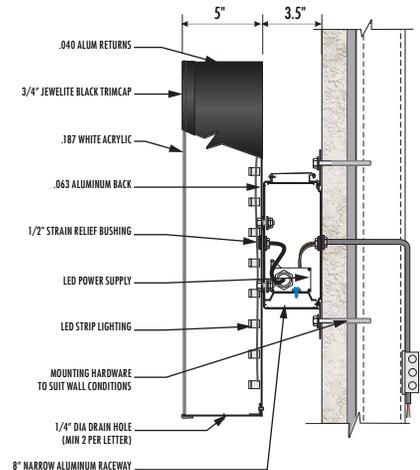

04-NORTH ELEVATION

Scale: 1/8" = 1'-0"



This sign is built to UL Standards for operation in North America.

"This Document is owned by, and the information contained in it is proprietary to, Parvin-Clauss Sign Company. By receipt hereof the holder agrees not to use the information, disclose it to any third party, nor reproduce this document without the prior written consent of Parvin-Clauss Sign Company. Holder also agrees to immediately return this document upon request of Parvin-Clauss Sign Company."

© Copyright 2019 by Parvin-Clauss Sign Co.

Parvin-Clauss
SIGN COMPANY

Design • Fabrication • Installation • Maintenance
 165TubewayDrive • CarolStream • Illinois 60188
 Tel/630-510-2020 • Fax/630-510-2074
 e-mail/signs@parvinclauss.com
 www.parvinclauss.com

PROJECT:



SEC Kirk Road & Main Street (Rt. 64)
 St. Charles, IL

CUSTOMER APPROVAL:
DATE

AUTHORIZED SIGNATURE

REPRESENTATIVE

House / RM / KZ

DRAWN BY

Bill Marlow

DATE

10.23.19

SCALE

1/2" = 1'

SHEET NO.

9 of 12

WORK ORDER

82989


FILE NAME

PRD82989

REVISIONS:

- 1 11.04.19
- 2
- 3
- 4
- 5
- 6
- 7
- 8

This sign is intended to be installed in accordance with the requirements of Article 600 of the National Electrical Code and/or other applicable local codes. This includes proper grounding and bonding of the sign.

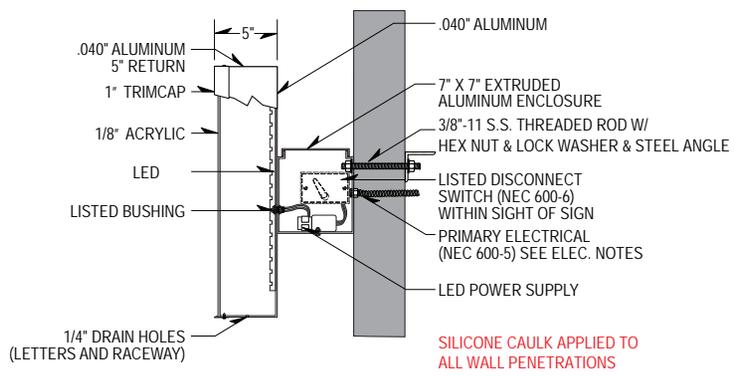


(1 set each) 5" Deep Illuminated Channel Letters on Raceways - 8.45 9F / 14.40 9F

Returns: Fabricated Aluminum Painted PMS 288 Blue
Faces: #7328 White Acrylic w/ 1" Jewelite White trimcap
Vinyl: 3M 3630-157 Sultan Blue Translucent Vinyl
Raceways: Std. 7" x 7" Aluminum Painted to Match Wall Color - SW 7063 Nebulous White
Illumination: White LED
Power: (1) 20Amp @ 120Volts Electrical Circuit Run to Site by Others
Mounting: Raceways Flush Mounted to Building - Appropriate Hardware for Wall Construction


*Bottom Raceway Mount
Upside Down*

NOTE: FIELD SURVEY REQUIRED PRIOR TO FABRICATION

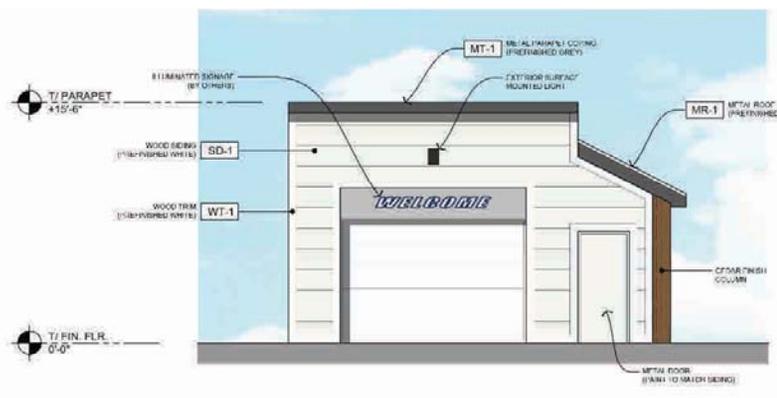

02 - WEST ELEVATION

Scale: 1/8" = 1'-0"

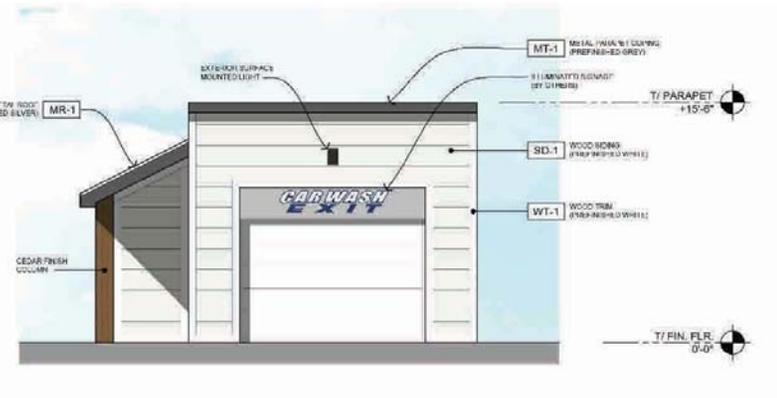

03 - EAST ELEVATION

Scale: 1/8" = 1'-0"

Parvin-Clauss
SIGN COMPANY

Design • Fabrication • Installation • Maintenance

165 Tubeway Drive • Carol Stream • Illinois 60188
 Tel/630-510-2020 • Fax/630-510-2074
 e-mail/signs@parvinclauss.com
 www.parvinclauss.com

PROJECT:



SEC Kirk Road & Main Street (Rt. 64)
St. Charles, IL

CUSTOMER APPROVAL:

DATE

AUTHORIZED SIGNATURE

REPRESENTATIVE

House / RM / KZ

DRAWN BY

Bill Marlow

DATE

10.23.19

SCALE

3/4" = 1'

SHEET NO.

10 of 12

WORK ORDER

82989

FILE NAME

PRD82989

REVISIONS:

1	11.04.19
2	
3	
4	
5	
6	
7	
8	


This sign is intended to be installed in accordance with the requirements of Article 600 of the National Electrical Code and/or other applicable local codes. This includes proper grounding and bonding of the sign.



This sign is built to UL Standards for operation in North America.

"This Document is owned by, and the information contained in it is proprietary to, Parvin-Clauss Sign Company. By receipt hereof the holder agrees not to use the information, disclose it to any third party, nor reproduce this document without the prior written consent of Parvin-Clauss Sign Company. Holder also agrees to immediately return this document upon request of Parvin-Clauss Sign Company."

© Copyright 2019 by Parvin-Clauss Sign Co.

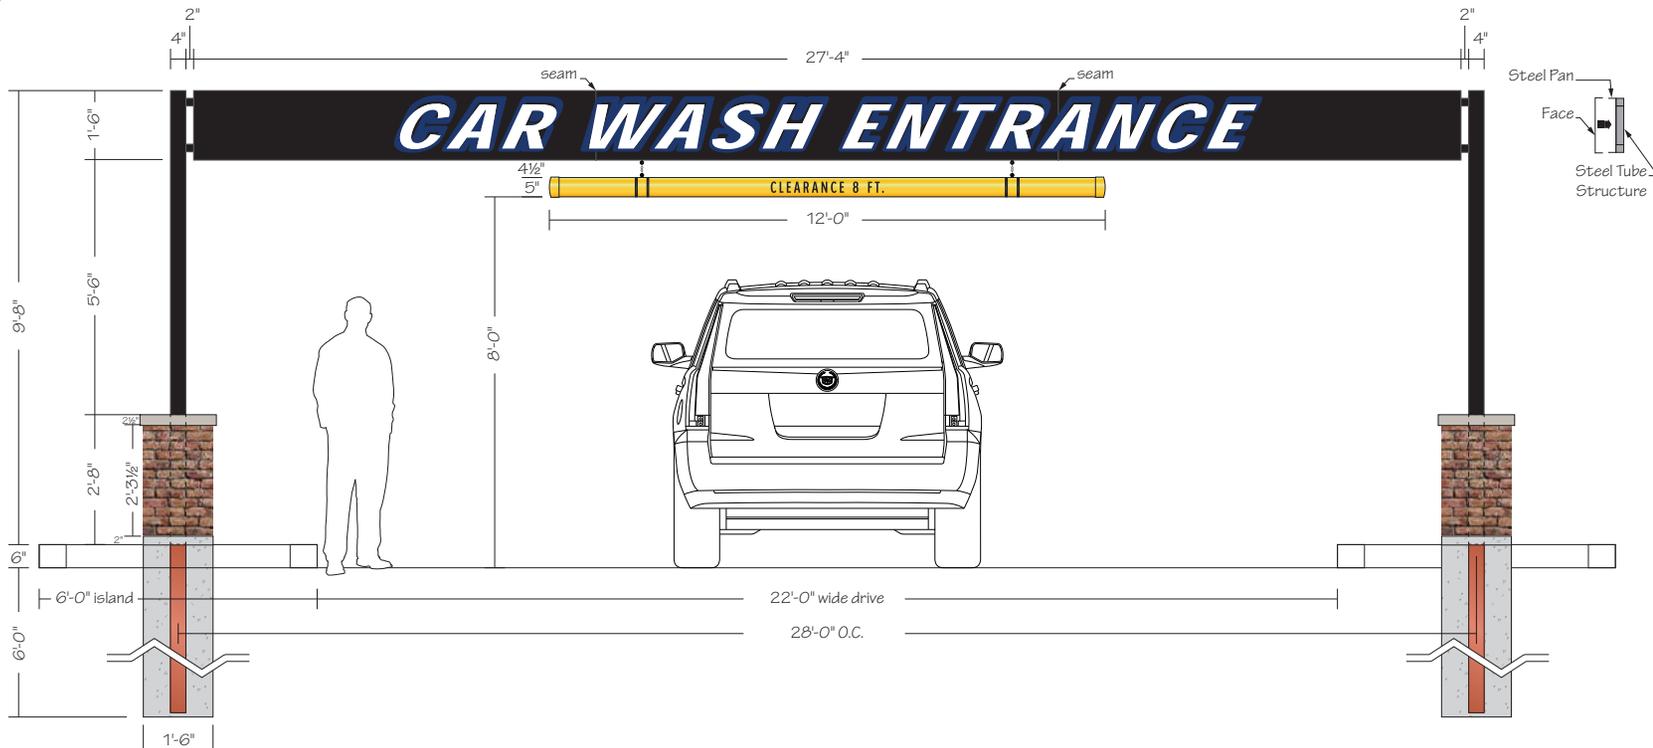

(1) 1'-6" x 27'-4" x 2" Single Face Non-Illuminated Entrance Gateway

Cabinet: Fabricated Aluminum Painted Black - Suede Satin Finish
 - 2" x 2" Tube Internal Structure

Graphics: 3M 7725-37 Sapphire Blue & 7725-10 White Vinyls

Clearance Bar: 5" PVC Pipe w/ Caps Painted MAP 42248 Sundance Yellow

Clearance Ht. Copy & Stripes: 3M 680-85 Black Reflective Vinyl

Bases: Masonry to Match Building - Redland Bayfrost (038) Brick

- Jumbo (05) Modular: 35/8" W x 2 3/4" H x 75/8" L

Mounting: (2) 4" x 4" Tube Steel set into (2) 1'-6" dia. x 6'-0" deep Concrete Foundations

NOTE: FIELD SURVEY REQUIRED PRIOR TO FABRICATION

Design • Fabrication • Installation • Maintenance

165TubewayDrive • CarolStream • Illinois 60188
 Tel/630-510-2020 • Fax/630-510-2074
 e-mail/signs@parvinclauss.com
 www.parcinclauss.com

PROJECT:



SEC Kirk Road & Main Street (Rt. 64)
 St. Charles, IL

CUSTOMER APPROVAL:

DATE _____

AUTHORIZED SIGNATURE _____

REPRESENTATIVE _____

House / RM / KZ

DRAWN BY _____

Bill Marlow

DATE _____

10.23.19

SCALE _____

3/8" = 1'

SHEET NO. _____

11 of 12

WORK ORDER _____

82989

FILE NAME _____

PRD82989

REVISIONS:

1	11.04.19
2	
3	
4	
5	
6	
7	
8	


This sign is intended to be installed in accordance with the requirements of Article 600 of the National Electrical Code and/or other applicable local codes. This includes proper grounding and bonding of the sign.



This sign is built to UL Standards for operation in North America.

This Document is owned by, and the information contained in it is proprietary to, Parvin-Clauss Sign Company. By receipt hereof the holder agrees not to use the information, disclose it to any third party, nor reproduce this document without the prior written consent of Parvin-Clauss Sign Company. Holder also agrees to immediately return this document upon request of Parvin-Clauss Sign Company."

© Copyright 2019 by Parvin-Clauss Sign Co.

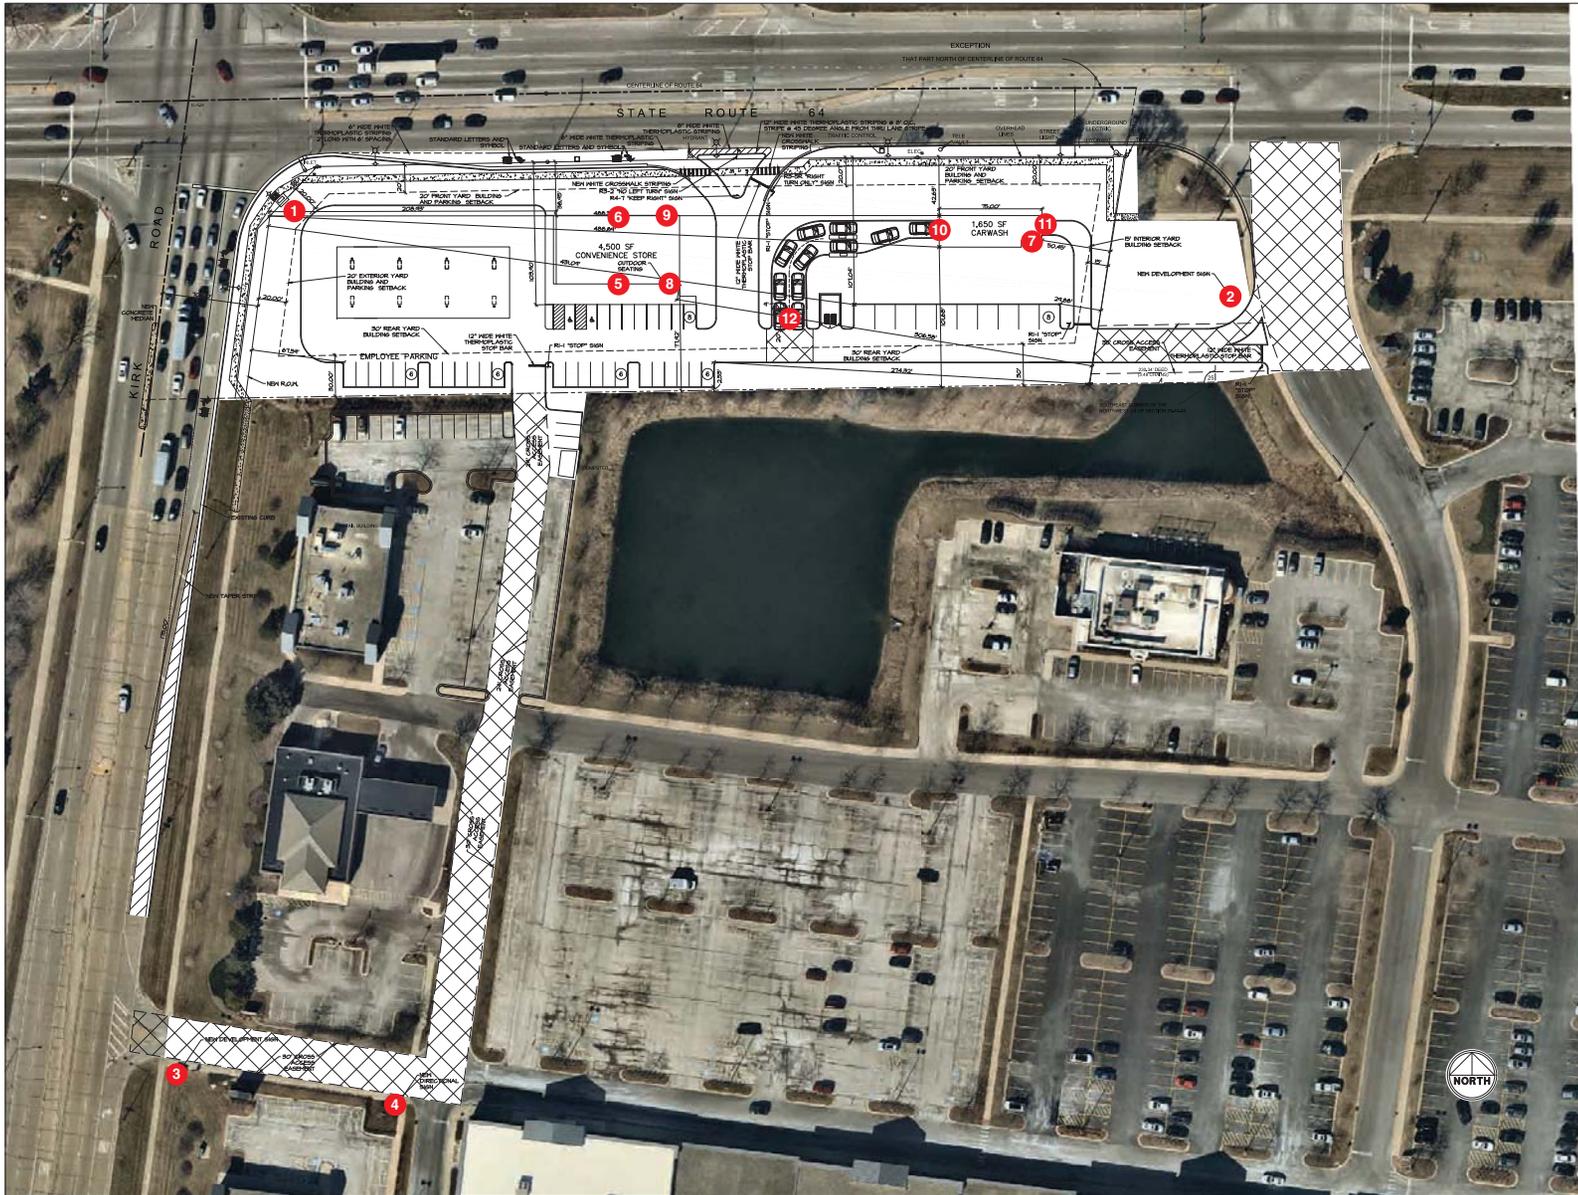

Parvin-Clauss SIGN COMPANY

Design • Fabrication • Installation • Maintenance

165TubewayDrive • CarolStream • Illinois 60188
Tel/630-510-2020 • Fax/630-510-2074
e-mail/signs@parvinclauss.com
www.parvinclauss.com

PROJECT:



SEC Kirk Road & Main Street (Rt. 64)
St. Charles, IL

CUSTOMER APPROVAL:

DATE

AUTHORIZED SIGNATURE

REPRESENTATIVE

House / RM / KZ

DRAWN BY

Bill Marlow

DATE

10.23.19

SCALE

nts

SHEET NO.

12 of 12

WORK ORDER

82989

FILE NAME

PRD82989

REVISIONS:

- 1 11.04.19
- 2
- 3
- 4
- 5
- 6
- 7
- 8

This sign is intended to be installed in accordance with the requirements of Article 600 of the National Electrical Code and/or other applicable local codes. This includes proper grounding and bonding of the sign.



This sign is built to UL Standards for operation in North America.

"This Document is owned by, and the information contained in it is proprietary to, Parvin-Clauss Sign Company. By receipt hereof the holder agrees not to use the information, disclose it to any third party, nor reproduce this document without the prior written consent of Parvin-Clauss Sign Company. Holder also agrees to immediately return this document upon request of Parvin-Clauss Sign Company."

© Copyright 2019 by Parvin-Clauss Sign Co.